

SITE DEVELOPMENT PLANS


FOR:
PROPOSED




WITH DRIVE-THRU

LOCATION OF SITE:

408 MASSACHUSETTS AVENUE, TOWN OF ACTON
MIDDLESEX COUNTY, MASSACHUSETTS
MAP F3, LOT 127

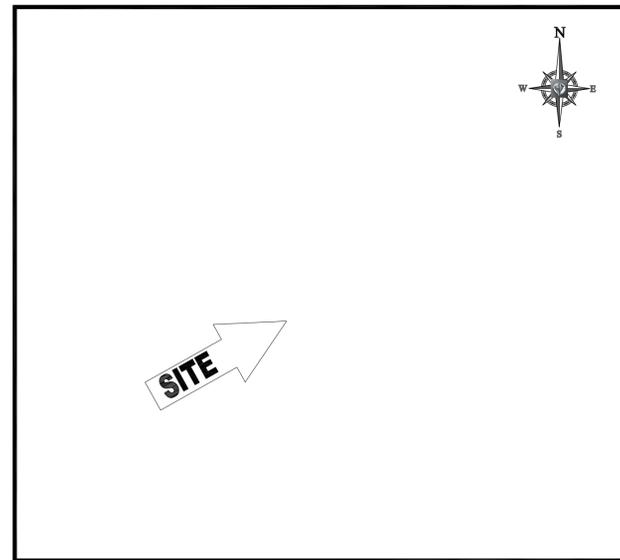

LOCATION MAP
SCALE: 1"=200'
PLAN REFERENCE: MASSGIS USGS IMAGE

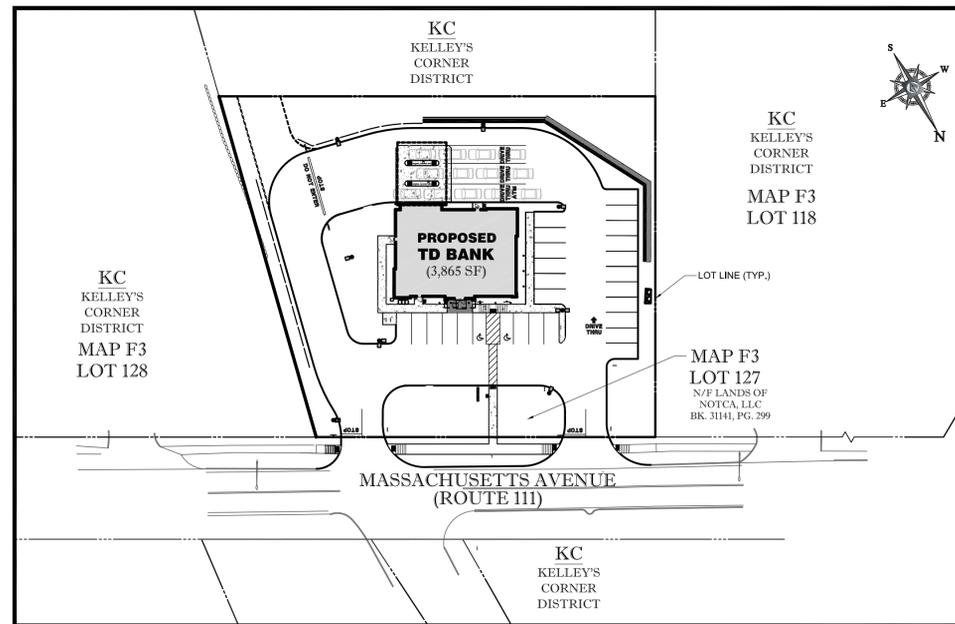

AREA PLAN
SCALE: 1"=50'

SHEET TITLE	SHEET NUMBER
COVER SHEET	1 OF 14
GENERAL NOTES SHEET	2 OF 14
DEMOLITION PLAN	3 OF 14
SITE PLAN	4 OF 14
GRADING PLAN	5 OF 14
DRAINAGE & UTILITY PLAN	6 OF 14
SOIL EROSION & SEDIMENT CONTROL PLAN	7 OF 14
SOIL EROSION CONTROL NOTES & DETAILS	8 OF 14
LANDSCAPE PLAN	9 OF 14
LANDSCAPE NOTES & DETAILS	10 OF 14
LIGHTING PLAN	11 OF 14
CONSTRUCTION DETAIL SHEET	12 OF 14
CONSTRUCTION DETAIL SHEET	13 OF 14
CONSTRUCTION DETAIL SHEET	14 OF 14
IRRIGATION NOTES & DETAILS (OMITTED)	1 OF 1
ALTA SURVEY (BY OTHERS)	1 OF 1

DRAWING INDEX

PROJECT TEAM CONTACTS

ARCHITECT	OWNER	APPLICANT
Bergmeyer BERGMAYER ASSOCIATES, INC., 51 SLEEPER STREET BOSTON, MA 02210 617-542-1025	NOTCA, LLC 408 MASSACHUSETTS AVENUE ACTON, MA 01720	 C/O BOHLER ENGINEERING 352 TURNPIKE ROAD SOUTHBOROUGH, MA 01772 508-480-9900

TOWN & UTILITY CONTACTS

BUILDING DEPARTMENT FRANK RAMSBOTTOM -INTERIM BLDG. COMM. 472 MAIN STREET ACTON, MA 01720 PHONE 978-264-9632 FAX 978-264-9630	PLANNING DEPARTMENT ROLAND BARTL -PLANNING DIRECTOR 472 MAIN STREET ACTON, MA 01720 PHONE 978-264-9636 FAX 978-264-9630	ENGINEERING DEPT. BRUCE STANSKI, P.E. -TOWN ENGINEER 472 MAIN STREET ACTON, MA 01720 PHONE 978-264-9628 FAX 978-264-9630	HEALTH DEPT. DOUG HALLEY -HEALTH DIRECTOR 472 MAIN STREET ACTON, MA 01720 PHONE 978-264-9634 FAX 978-264-9630	TELEPHONE STEVE CENTRELLA -OSP ENGINEER VERIZON 185 FRANKLIN STREET BOSTON, MA 02107 PHONE 508-795-3150
ZONING DEPARTMENT SCOTT MUTCH -ZONING OFFICER 472 MAIN STREET ACTON, MA 01720 PHONE 978-264-9636 FAX 978-264-9630	TRAFFIC DEPARTMENT RUSSELL ROBINSON -SUPERINTENDENT 14 FOREST ROAD ACTON, MA 01720 PHONE 978-264-9624 FAX 978-264-9610	FIRE DEPARTMENT ROBERT CRAIG -FIRE CHIEF 472 MAIN STREET ACTON, MA 01720 PHONE 978-264-9645 FAX 978-263-9887	WATER DISTRICT CHRIS ALLEN -DISTRICT MANAGER 693 MASSACHUSETTS AVE., PO BOX 953 ACTON, MA 01720 PHONE 978-263-9107 FAX 978-264-0148	ELECTRIC BRUCE KM -COMMERCIAL SALES NSTAR 1 N STAR WAY WESTWOOD, MA 02090 PHONE 781-441-8889

PREPARED BY



BOHLER ENGINEERING

CORPORATE OFFICE:
WARREN, NJ

OFFICES:
 CHALFONT, PA
 PHILADELPHIA, PA
 SOUTHBOROUGH, MA
 SOUTH BRITAIN, VA
 WESTWOOD, MA

PROJECT MANAGERS:
 BOWNE, MD
 ALBANY, NY
 ROKONONOMA, NY
 CENTER VALLEY, PA

ENVIRONMENTAL CONSULTANTS:
 LANDSCAPE ARCHITECTS:
 CENTER VALLEY, PA

CIVIL & CONSULTING ENGINEERS:
 SURVEYORS

FROM PLANET PAPERLESS, INC. (A PRODUCT OF PLANET PAPERLESS, INC. 1-800-828-7962)

REVISIONS

REV	DATE	COMMENT	BY
1			
2			
3			
4			
5			
6			
7			
8			
9			

THE FOLLOWING STATES REQUIRE NOTIFICATION BY EXCAVATORS, DESIGNERS, OR ANY PERSON PREPARING TO DISTURB THE EARTH'S SURFACE ANYWHERE IN THE STATE:
 MA, ME, NH, RI, VT 1-888-344-7233
 (CT 1-800-822-4655)
 (NY 1-800-962-7962)

PERMIT SET

PROJECT No.: W081068
 DRAWN BY: KBS
 CHECKED BY: JGS
 DATE: 4/25/10
 SCALE: AS NOTED
 CAD I.D.: W081068S50

SITE PLAN DOCUMENTS

FOR

408 MASSACHUSETTS AVENUE
 MIDDLESEX COUNTY
 ACTON, MASSACHUSETTS

BOHLER ENGINEERING

352 TURNPIKE ROAD
 SOUTHBOROUGH, MA 01772
 Phone: (508) 480-9900
 Fax: (508) 480-9080
www.BohlerEngineering.com

W.D. GOEBEL

PROFESSIONAL ENGINEER
 MASSACHUSETTS LICENSE No. 42644
 RHODE ISLAND LICENSE No. 7285
 CONNECTICUT LICENSE No. 21854
 NEW HAMPSHIRE LICENSE No. 10290
 MAINE LICENSE No. 9490

SHEET TITLE:
COVER SHEET

SHEET NUMBER:
1
OF 14

REV. 0